


ROOF PLAN

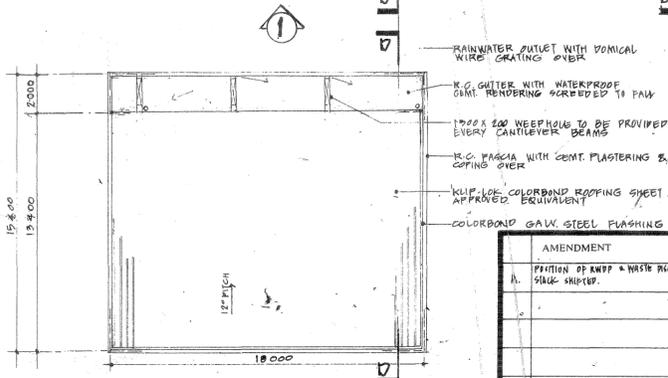

ROOF PLAN OF WATER TANK & LIFT MOTOR ROOM

MICROFILMED
25 FEB 1981

AMENDMENT	BY	CHECK	DATE	CONTRACT BUILDING	This is the drawing No. HB 1904-82-4A Referred to in the contract No. and Signed between us this day of 19.....	DRAWING NO. HB. 1904-82-4A	SCALE: 1:200	TEAMS: 10
A		TIG	14/6	JOB TITLE DEPU INDUSTRIAL PARK 'D' CONTRACT 3B		DRAWN BY: KIMEE	DATE: 8-3-82	TEAM LEADER: TAN TAY KOHAN
				DRAWING TITLE BLOCKS 30B31 ROOF PLAN.	Contractor Date	CHECKED BY: AMNH	ARCH. CO-ORDINATOR: HENG P. S.	CHIEF ARCHITECT: TONY TAN KENG JOO
REFERENCE					Witness			

TYPE B8

LIU THAI KER
Chief Executive Officer

HOUSING & DEVELOPMENT BOARD